


日期	专业	日期	专业
签字	暖通	签字	方案
	给排水		建筑
	电气		结构

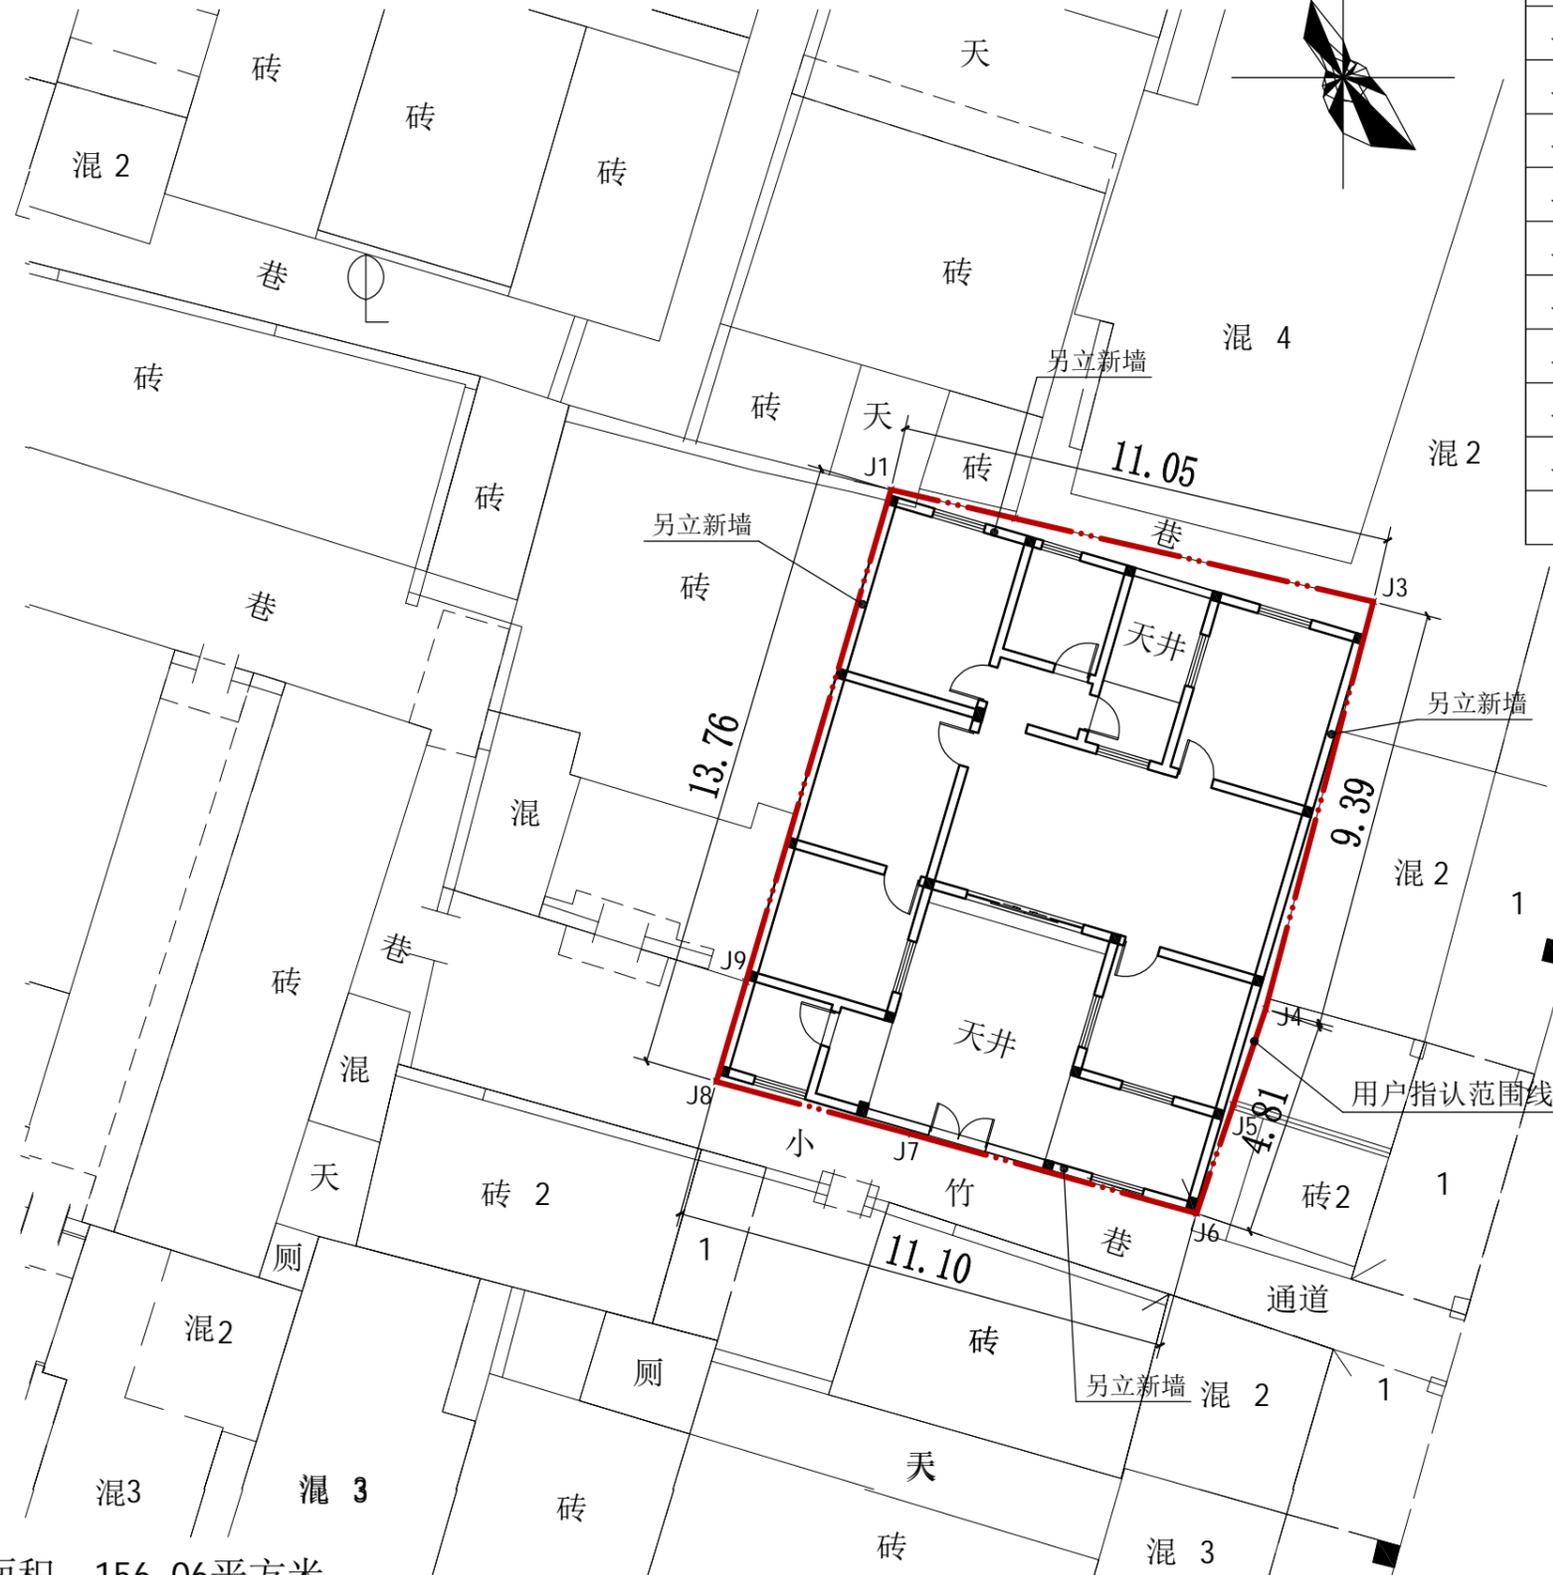

用地面积: 156.06平方米
 建筑面积: 119.41平方米
 建筑基底面积: 119.41平方米

总平面图 1:150

界址点坐标表			
点号	X	Y	边长
J1	2618045.286	39463753.058	2.84
J2	2618044.646	39463755.820	8.21
J3	2618042.793	39463763.818	9.39
J4	2618033.713	39463761.415	2.25
J5	2618031.581	39463760.692	2.56
J6	2618029.159	39463759.872	6.59
J7	2618030.918	39463753.521	4.51
J8	2618032.093	39463749.163	2.32
J9	2618034.319	39463749.821	11.44
J1	2618045.286	39463753.058	

S=156.06 平方米 合0.234亩

设计单位 DESIGN UNIT			
 顺道工程设计有限公司 工程设计证书编号: A235046756			
说明 本图纸的版权,属顺道工程设计有限公司所有,不得用于本工程以外范围。 本图纸需手续齐全方可用于施工。			
设计专用章 DESIGN APPROPRIATION CHAPTER			
注册执业章 REGISTERED SEAL			
建设单位 ORGANIZATION 湘桥区太平路466号 邢四记			
项目名称 ITEM NAME 住宅楼			
子项名 SUB PROJECT			
图纸名称 DRAWING TITLE 总平面图			
项目负责人 PROJECT DIRECTOR	赵新宇		
审定人 APPROVED BY	李溪喧		
专业负责人 DISCIPLINE RESPONSIBLE BY	赵新宇		
审核人 EXAMINED BY			
校对 CHECKED BY	赵新宇		
设计人 DESIGNED BY	叶珊珊		
制图人 DESIGNED BY	叶珊珊		
设计编号 PROJECT No.			
版次 VERSION	A	图号 DRAWING NO.	建-01
比例 SCALE		日期 DATE	2024.03
专业	建筑	图别	方案图