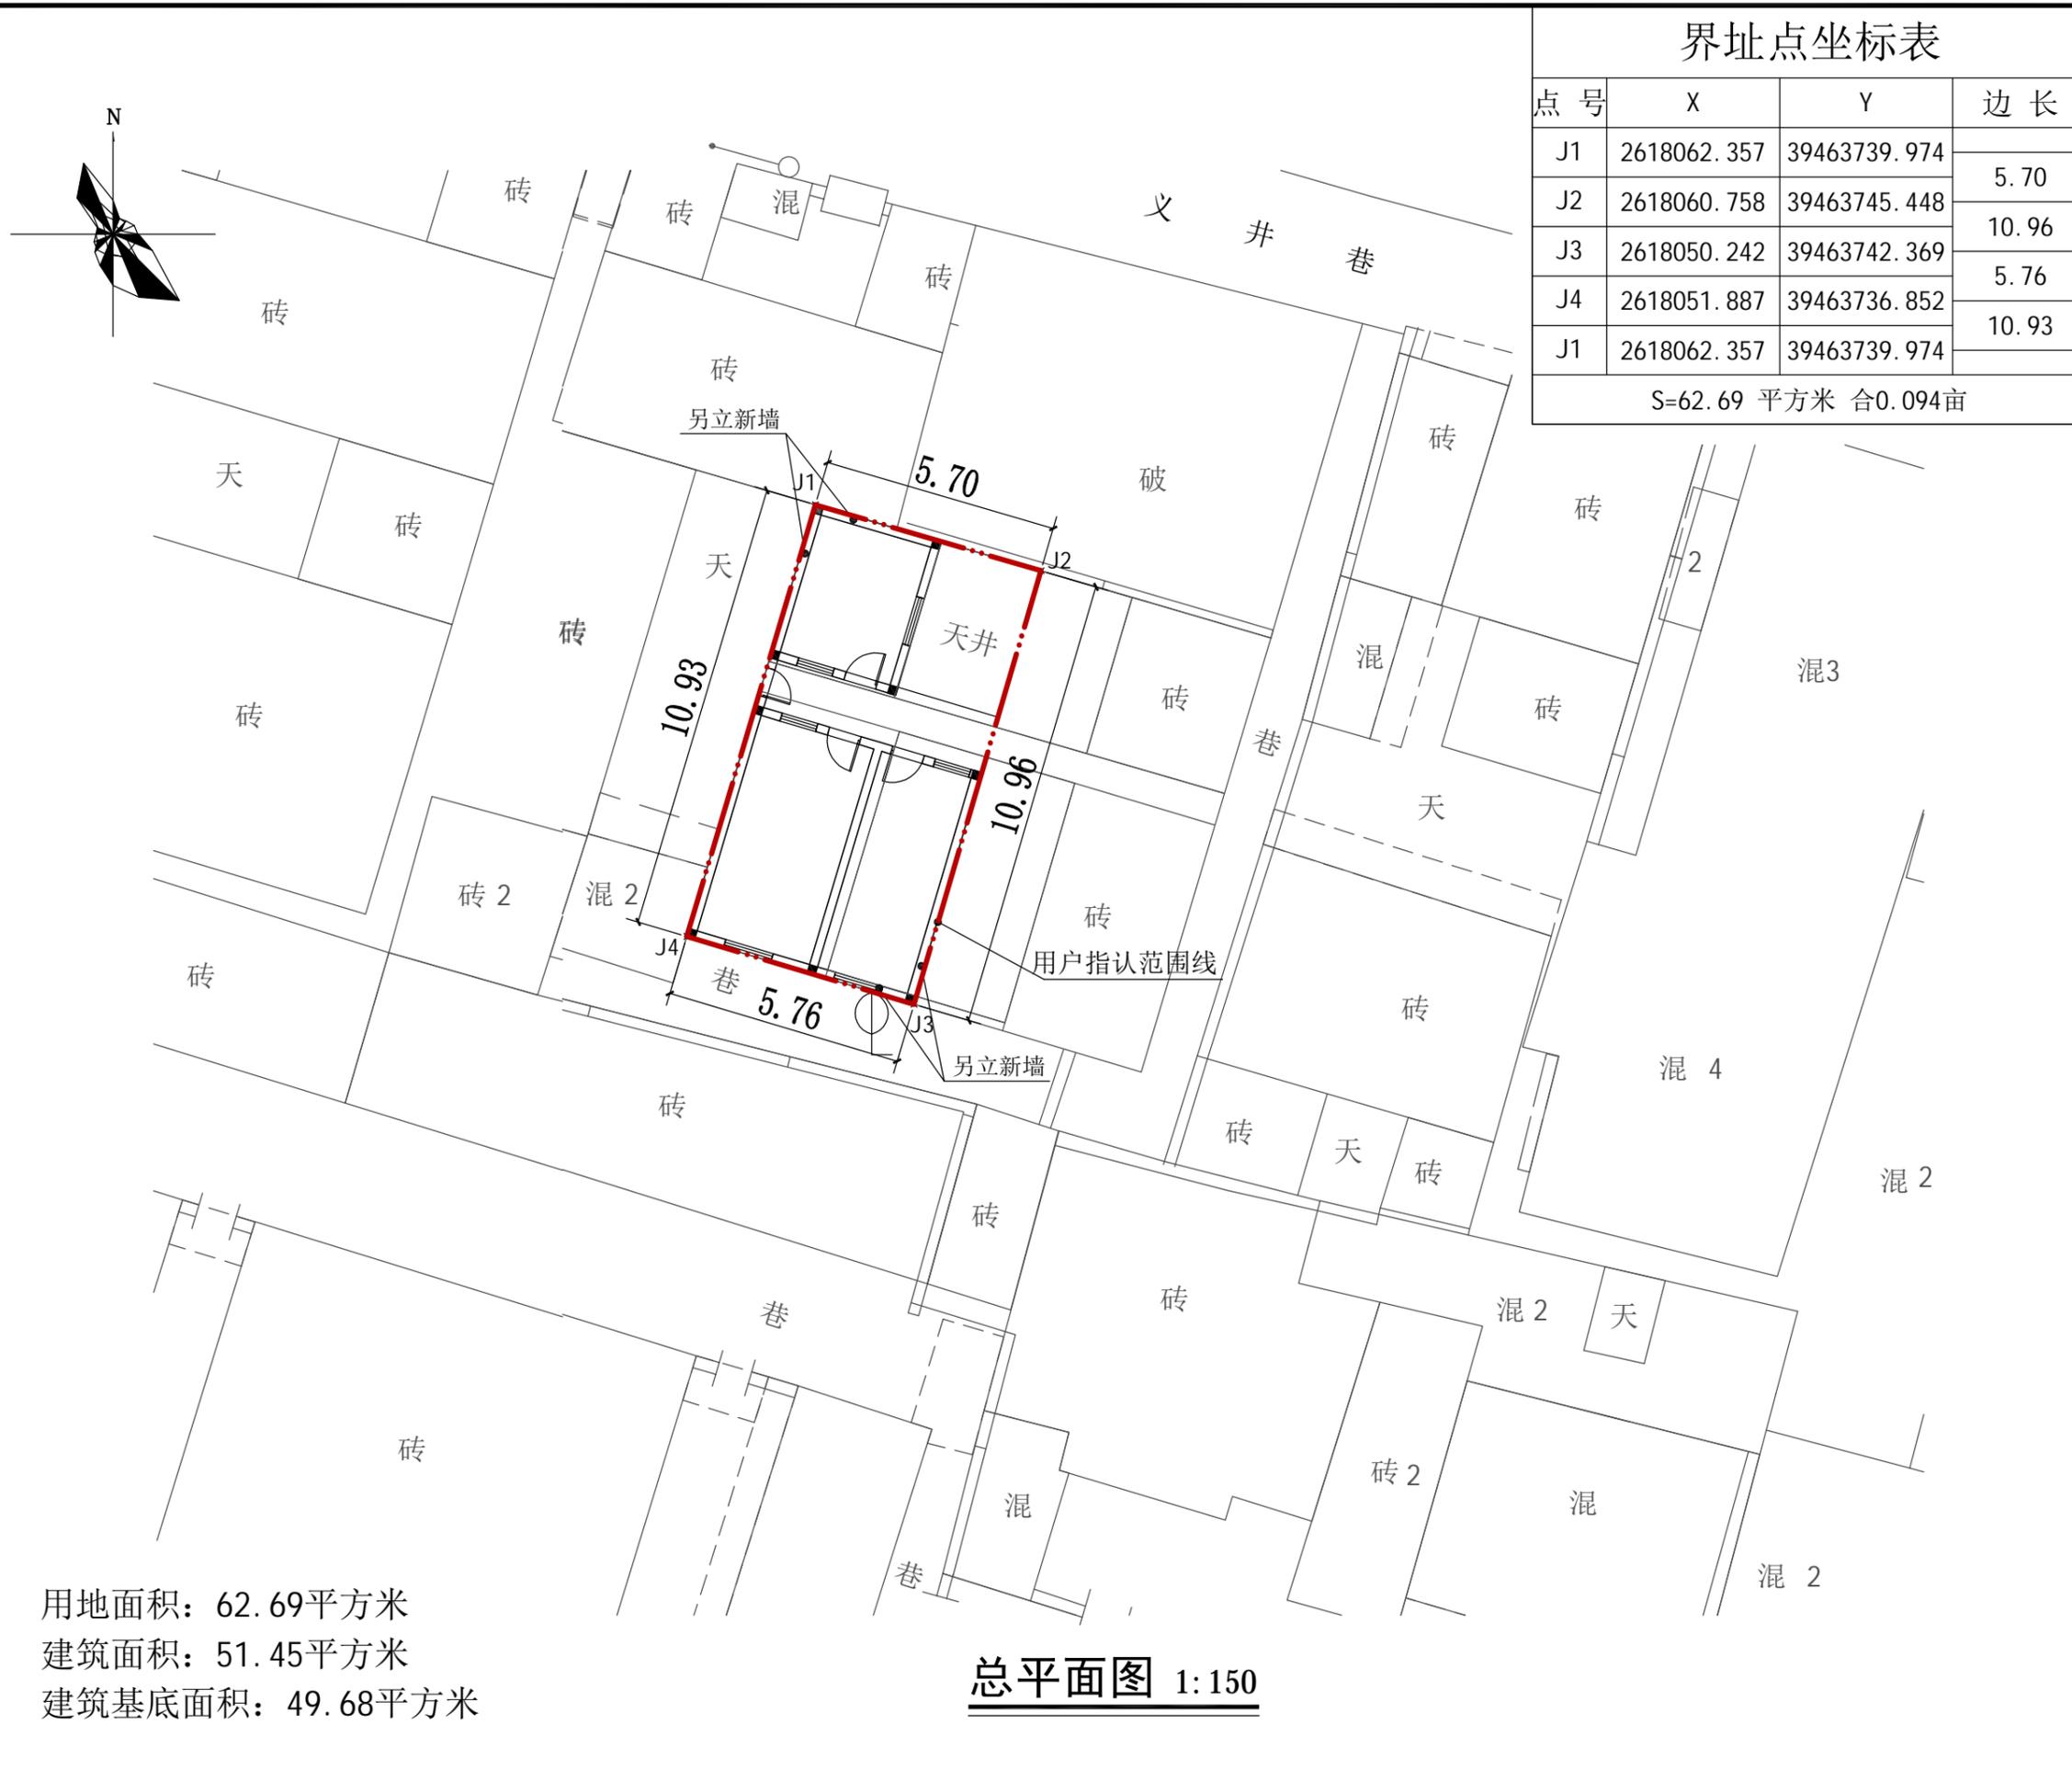


日期			
签字			
专业	暖通	给排水	电气
日期			
签字			
专业	方案	建筑	结构

 
 
 
 
 


用地面积: 62.69平方米  
 建筑面积: 51.45平方米  
 建筑基底面积: 49.68平方米

**总平面图 1:150**

界址点坐标表

点号	X	Y	边长
J1	2618062.357	39463739.974	5.70
J2	2618060.758	39463745.448	10.96
J3	2618050.242	39463742.369	5.76
J4	2618051.887	39463736.852	10.93
J1	2618062.357	39463739.974	
S=62.69 平方米 合0.094亩			

设计单位 DESIGN UNIT		 顺道工程设计有限公司 工程设计证书编号: A235046756	
说明 本图纸的版权,属顺道工程设计有限公司所有,不得用于本工程以外范围。 本图纸需手续齐全方可用于施工。			
设计专用章 DESIGN APPROPRIATION CHAPTER			
注册执业章 REGISTERED SEAL			
建设单位 ORGANIZATION		湘桥区义井巷5/5号	
项目名称 ITEM NAME		住宅楼	
子项名 SUB PROJECT			
图纸名称 DRAWING TITLE 总平面图			
项目负责人 PROJECT DIRECTOR	赵新宇		
审定人 APPROVED BY	李溪喧		
专业负责人 DISCIPLINE RESPONSIBLE BY	赵新宇		
审核人 EXAMINED BY			
校对 CHECKED BY	赵新宇		
设计人 DESIGNED BY	叶珊珊		
制图人 DESIGNED BY	叶珊珊		
设计编号 PROJECT No.			
版次 VERSION	A	图号 DRAWING NO.	建-01
比例 SCALE		日期 DATE	2024.03
专业	建筑	图别	方案图